


aedis
INCORPORATED
ARCHITECTS * PLANNERS * INTERIORS
2317 CLAYTON ROAD
CLAYTON, MO 63117
PH: 314-682-1101 FAX: 314-682-8001
EMAIL: AEDISINC@AOL.COM

STRUCTURAL ENGINEER
IBRAHIM ENGINEERING CORP.
11500 OLIVE BLVD., SUITE 200
ST. LOUIS, MO 63141
Phone: (314) - 567-0196
Fax: (314) - 567-6158

G&W
Engineering
Corporation
38 Washington Access Drive
Saint Louis, MO 63104
(314) 469-3729
(314) 469-9468
www.gwengineering.com
Project No. 02-224

BANK MIDWEST

HIGHWAY K
O'FALLON, MO

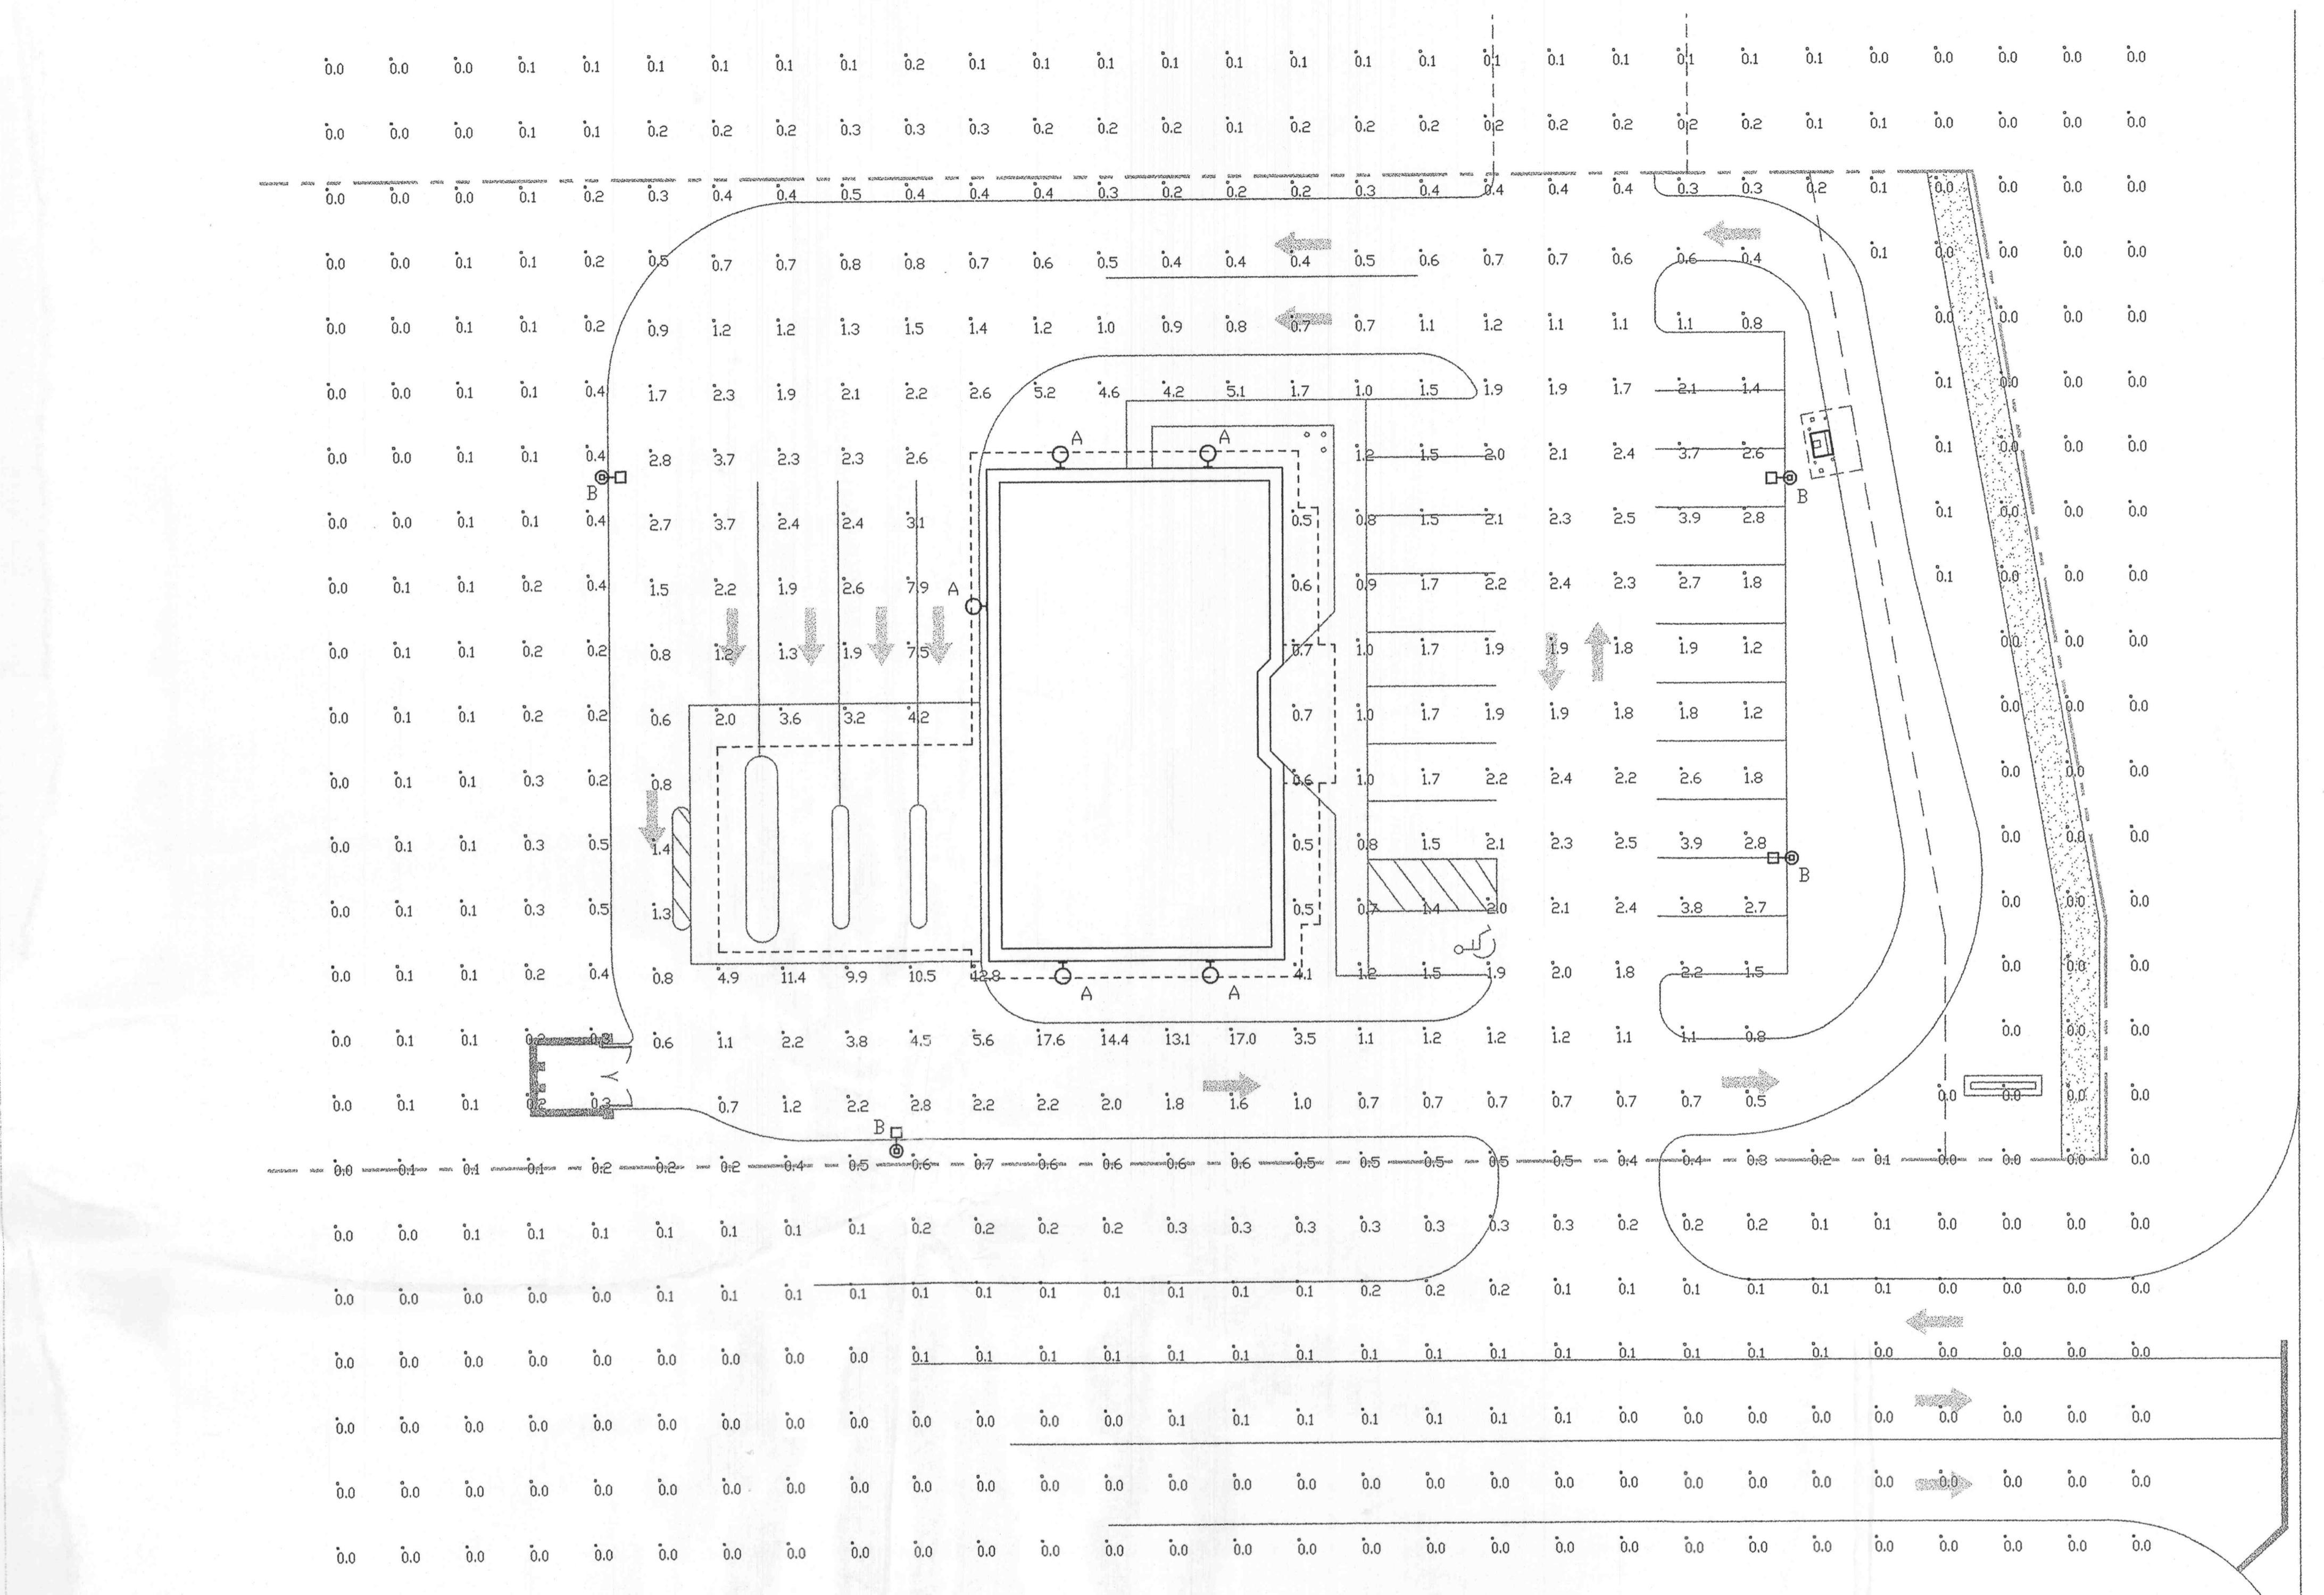

SITE PLAN - PHOTOMETRIC

SCALE: 1/16" = 1'-0"

Luminaire Schedule						
Symbol	Qty	Label	Arrangement	Lumens	LLF	Description
□	5	A	SINGLE	20800	0.720	MHT-250
□	4	B	SINGLE	36000	0.720	VXN-400-MH-SLE
○	12	C	SINGLE	14000	0.720	M7010T-750

Numeric Summary						
Label	CalcType	Units	Avg	Max	Min	Avg/Min
PARKING LDT	Illuminance	Fc	2.31	17.6	0.4	5.78
SPILL LIGHT	Illuminance	Fc	0.69	0.7	0.0	0.66
CANOPY	Illuminance	Fc	43.48	60.9	27.8	1.56

POLE FIXTURES MOUNTED AT 25'

These Drawings and Specifications are the confidential and proprietary property of G&W Engineering Corporation and shall not be copied or reproduced without written consent of the owner. Contract Documents were prepared for use on this specific site in conjunction with the services and materials furnished and are not suitable for use on a different site or at a different time unless specifically drawn for use on a different site or at a different time by a registered and properly licensed Architects and Engineers. It is the responsibility of the Contractor to determine if these drawings for reference or example can be used on another project. It is the responsibility of properly licensed Architects and Engineers to determine if these drawings for reference or example can be used on another project. It is the responsibility of the Contractor to use these drawings for reference or example on another project if not authorized.

ISSUE / REVISIONS
NO. DATE DESCRIPTION
1 09/09/00

DRAWN BY: PKB

SHEET TITLE:
SITE UTILITY PLAN

PROJECT #03-219

SEAL

SHEET NO.

E5.0

BANK
MIDWEST