
CONSTRUCTION ISSUE DECEMBER 5, 1997

Project No. 96036 Date SEPT. 4, 1997

Drawing No.

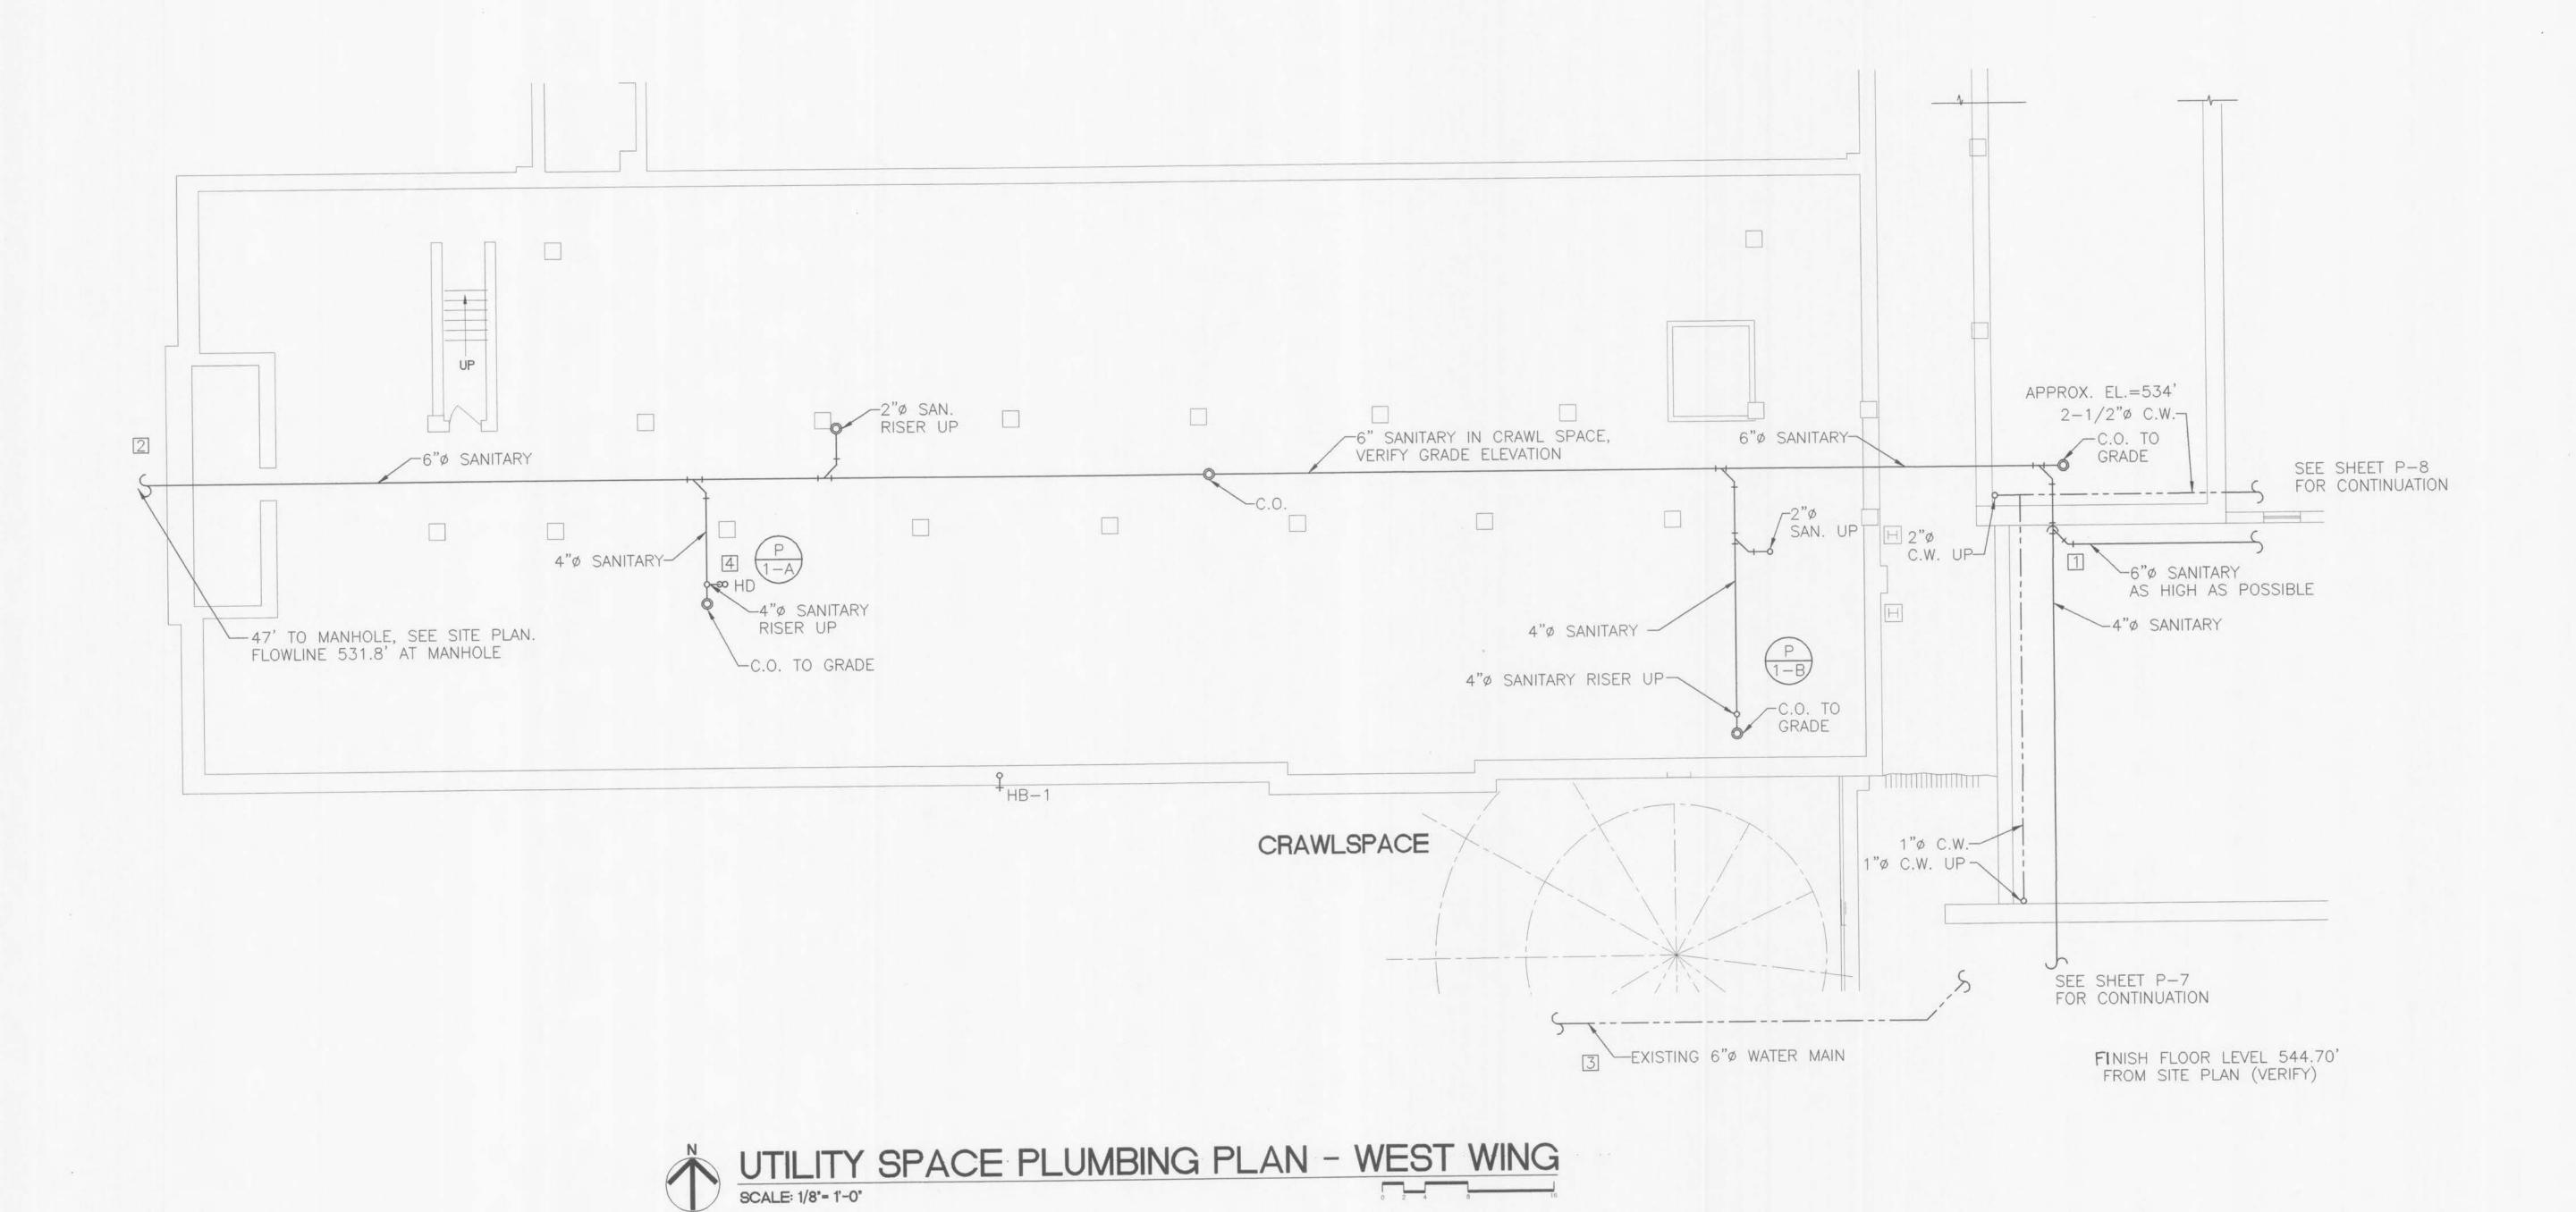

KEYED NOTES:

- 1 SANITARY WASTE DOWN APPROXIMATELY 18" AT THIS POINT FROM ELEVATED SANITARY LINE IN BASEMENT. VERIFY FINAL ELEVATIONS FROM FARTHEST POINT IN BASEMENT PRIOR TO ESTABLISHING TIE-IN.
- 2 CORE DRILL FOUNDATION WALL AS REQUIRED TO ACCEPT NEW 6" SANITARY MAIN.
- 3 BASE BID: CONNECT NEW 6" WATER SERVICE WITH BACKFLOW PREVENTER IN MECH/ELECTRICAL ROOM. SEE SHEET P-8 AND FIRE PROTECTION PLANS.

ALTERNATE BID: CONTRACTOR TO PROVIDE ALTERNATE COST TO REMOVE AND REPLACE EXISTING WATER MAIN WITH NEW 6" MAIN (APPROXIMATELY 440 LIN. FT.). FURNISH NEW BUILDING SHUTOFFS (O'FALLON AND ST. MARY'S FACILITIES) BACKFLOW PREVENTER AND WATER METERS.

4 HUB DRAIN FOR MECHANICAL UNIT CONDENSATE.

CONSTRUCTION DOCUMENTS

P-1